



Formerly Macy's


3850 Rivertown Parkway Grandville, MI 49418

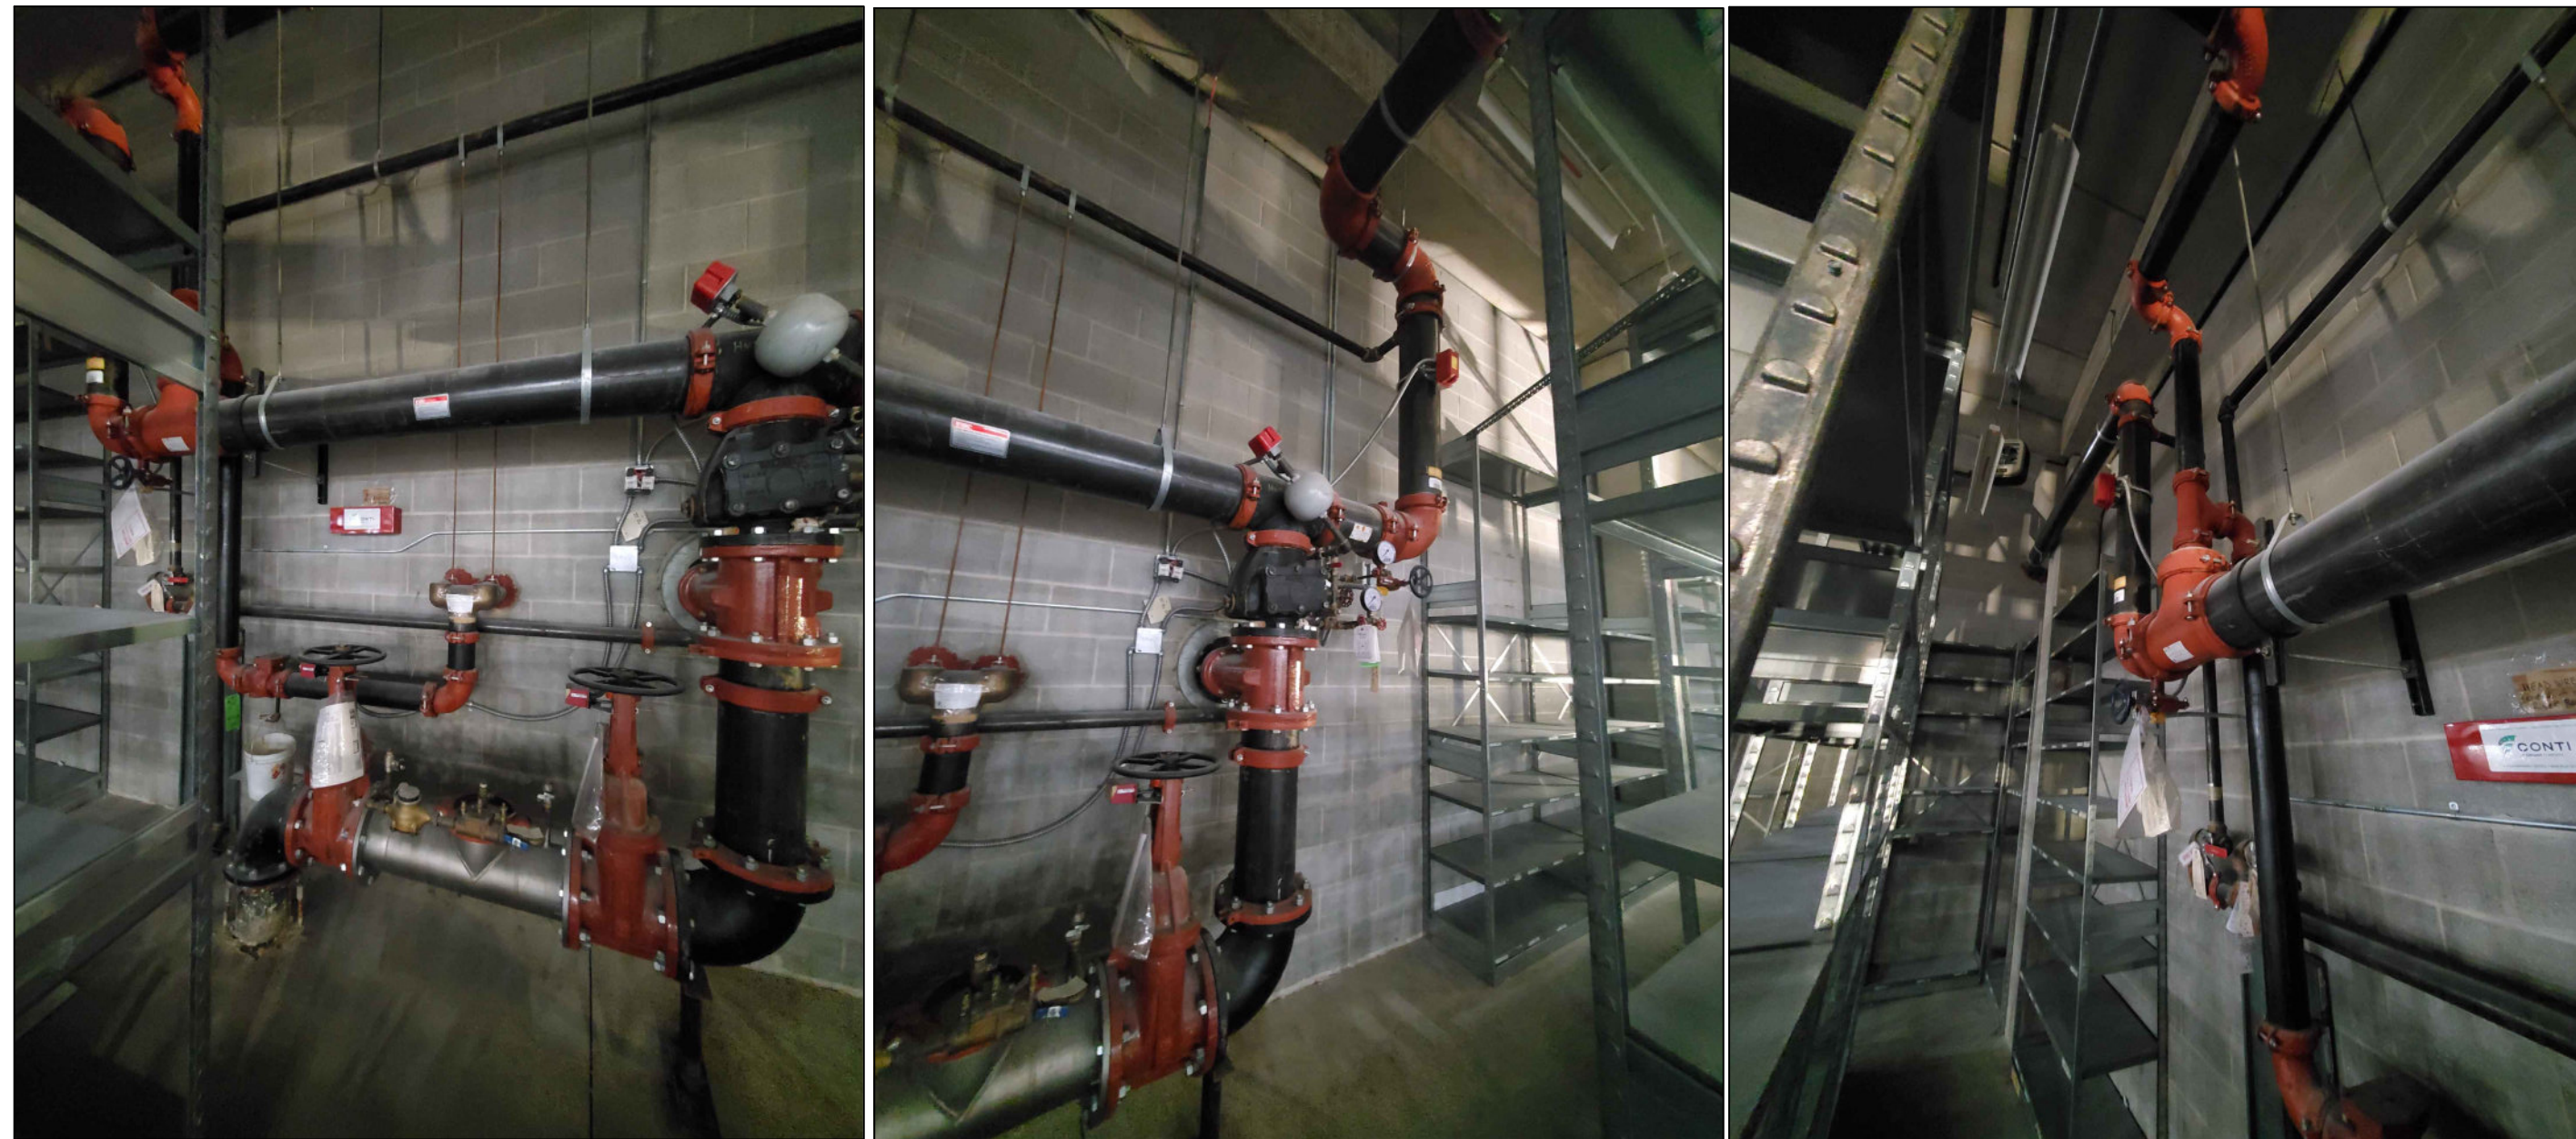


NORTH RISER BANK
NO SCALE

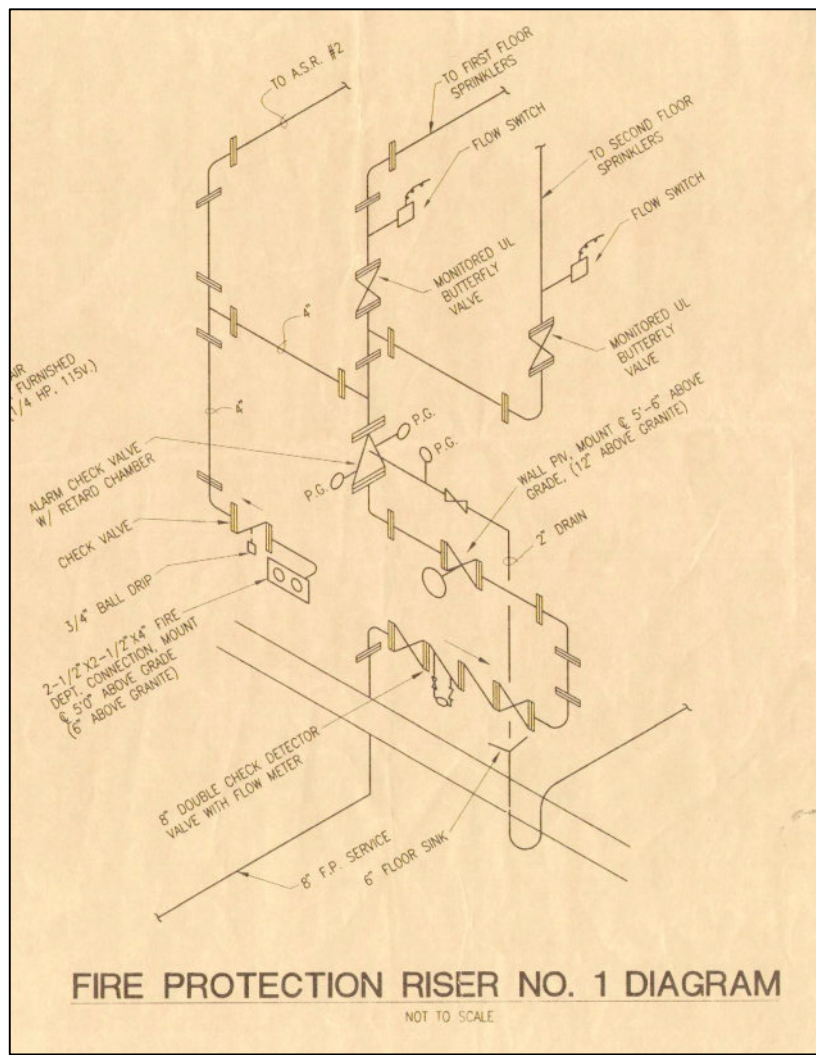


ORIGINAL NORTH RISER SCHEMATIC
NO SCALE

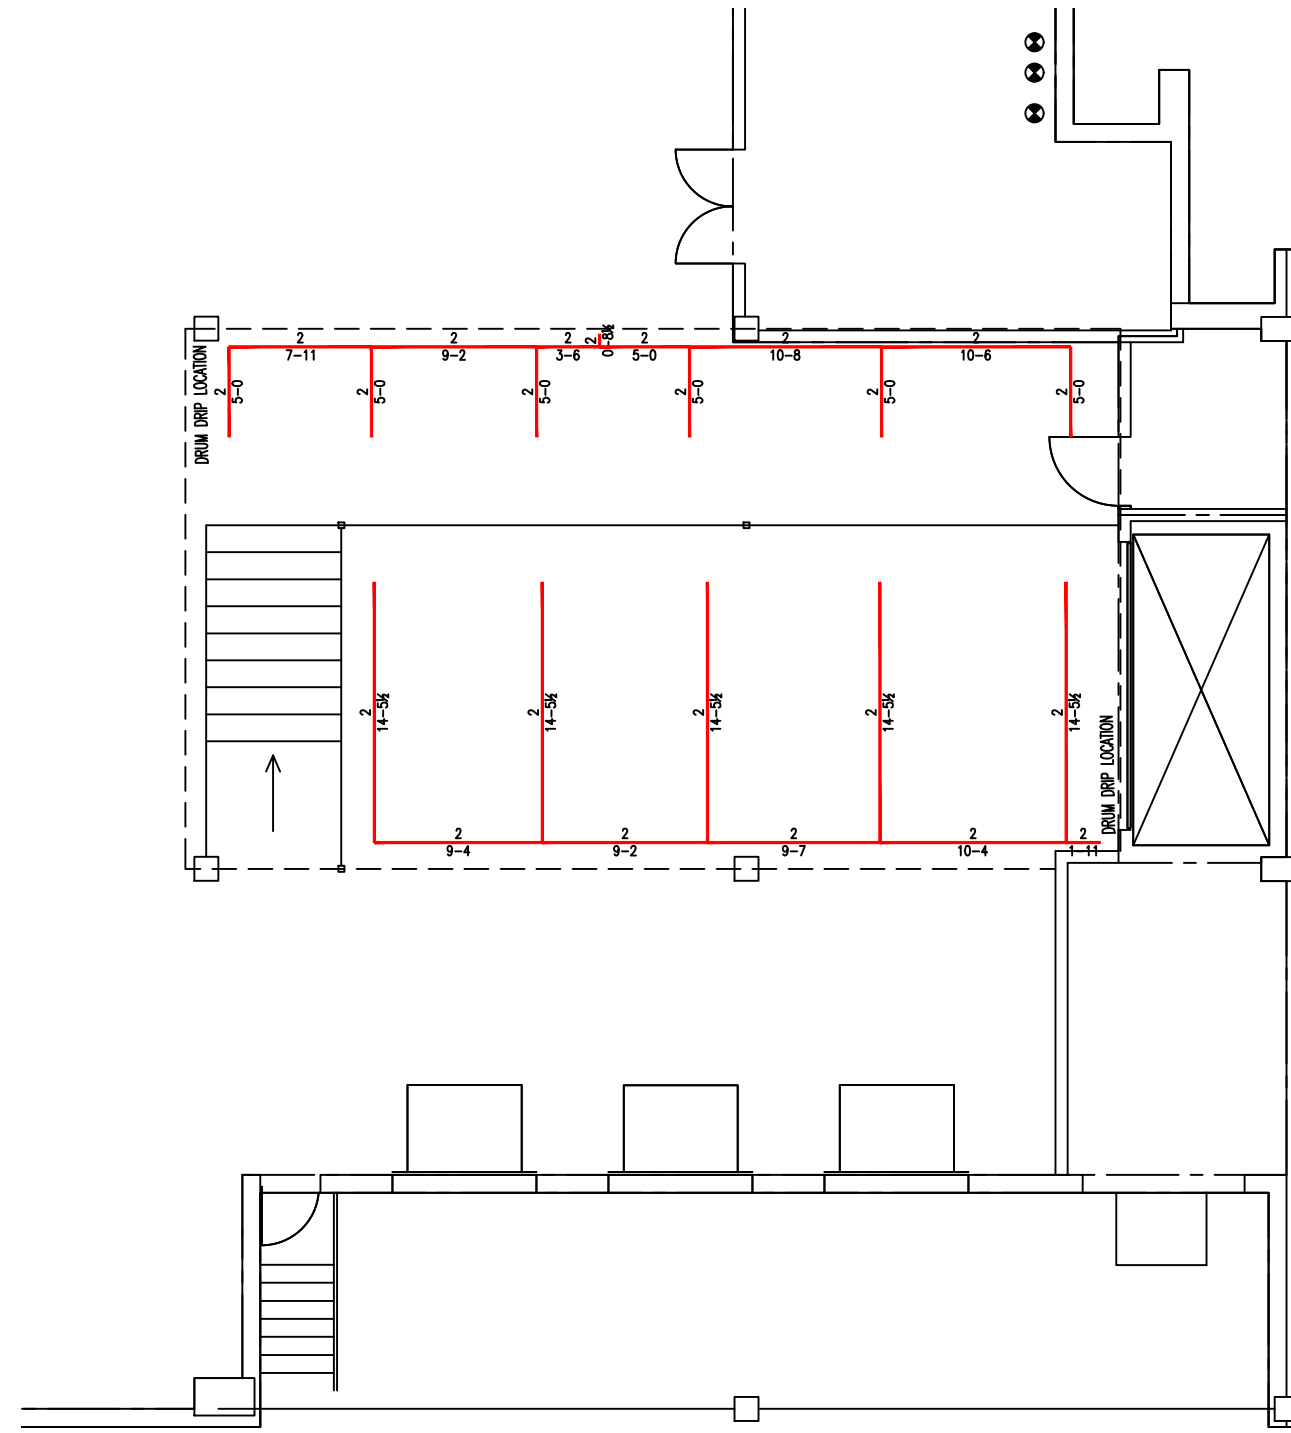


MEZZ EXISTING SPRINKLER PIPING LAYOUT
 $3/32" = 1'-0"$

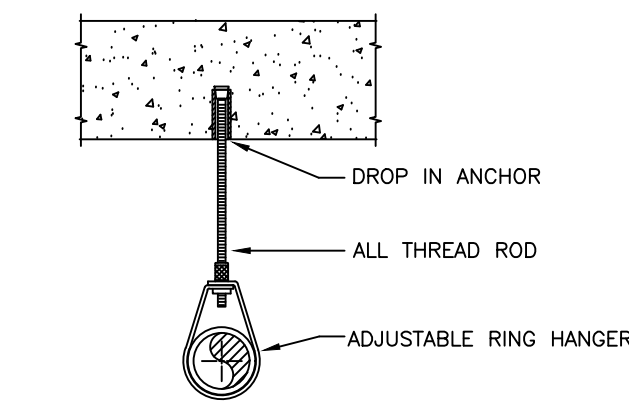



TYPICAL HANGER DETAIL
NO SCALE

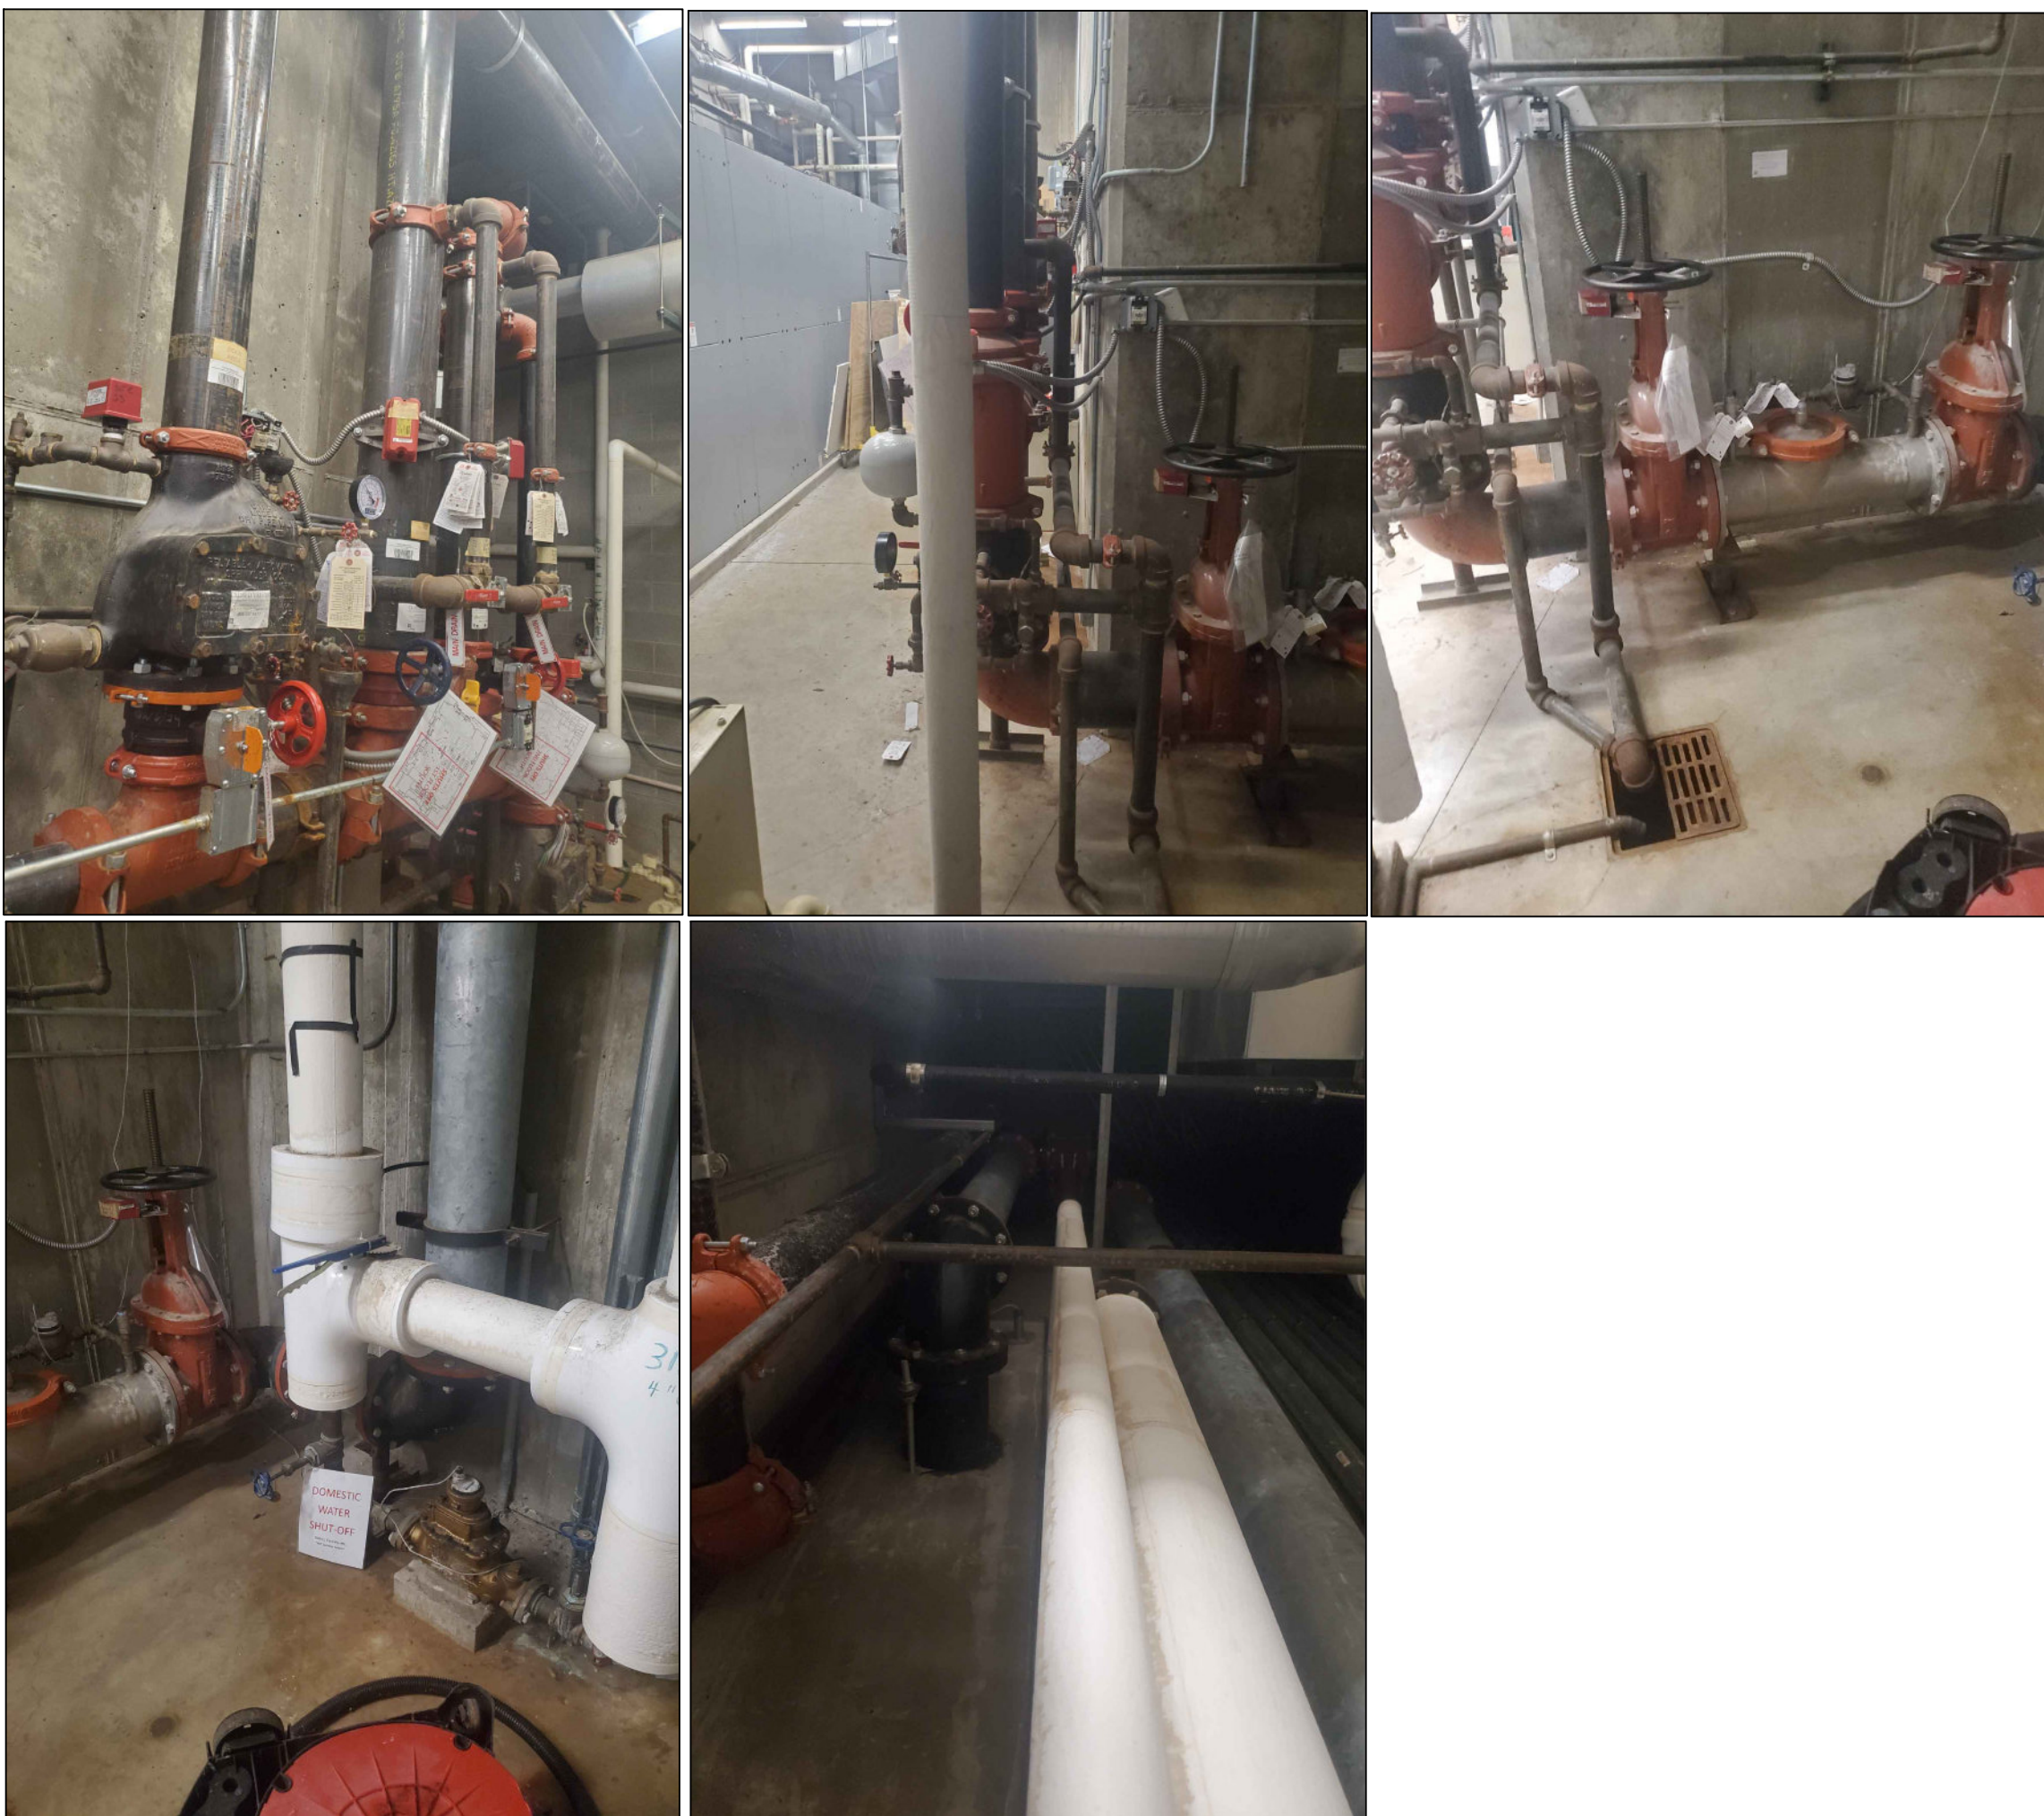

SOUTH RISER BANK
NO SCALE

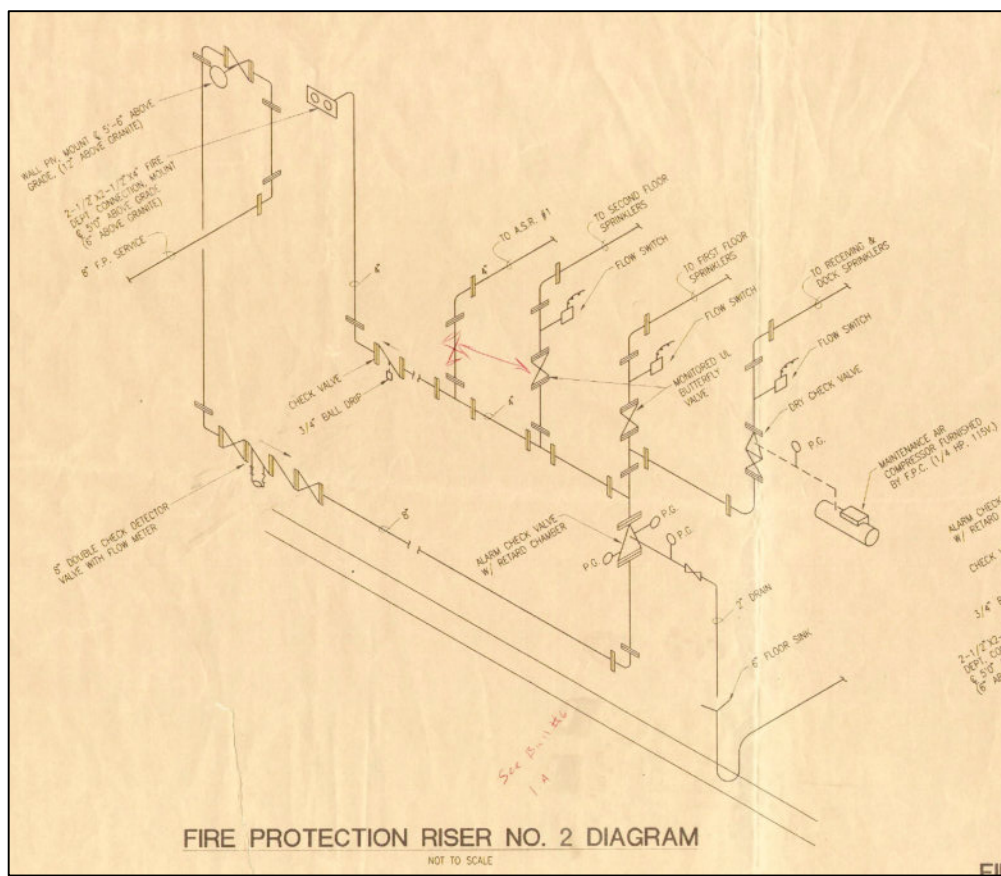

ORIGINAL SOUTH RISER SCHEMATIC
NO SCALE

 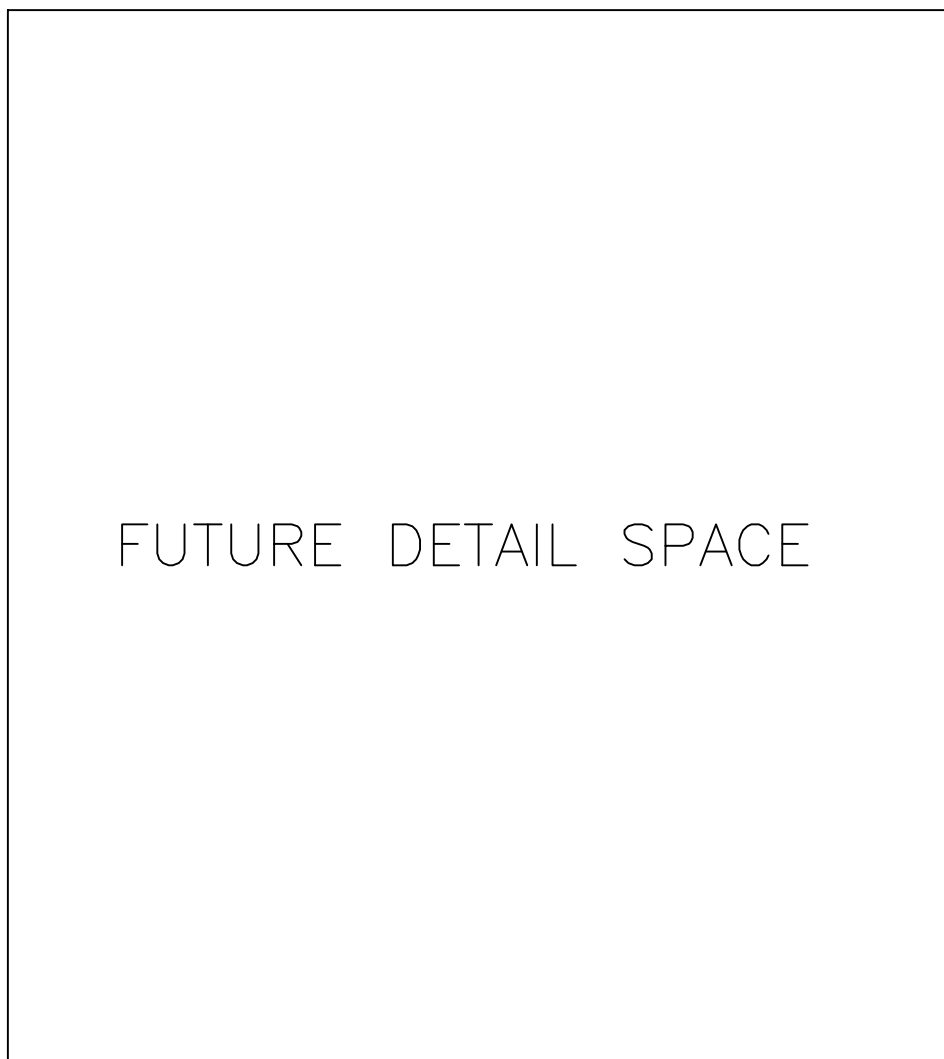

SITE MAP
NO SCALE

Sheet Index:
FP1- Notes/Riser/Details
FP2- 1st Floor
FP3- 2nd Floor

WARNING:
THIS DRAWING AND ANY INFORMATION CONTAINED HEREIN ARE THE PROPERTY OF DEPENDABLE FIRE PROTECTION, INC. AND ARE NOT TO BE REPRODUCED OR TRANSMITTED IN ANY FORM OR BY ANY MEANS, ELECTRONIC OR MECHANICAL, INCLUDING PHOTOCOPYING, RECORDING, OR BY ANY INFORMATION STORAGE AND RETRIEVAL SYSTEM, WITHOUT THE WRITTEN PERMISSION OF DEPENDABLE FIRE PROTECTION, INC. 12/15/2015
DEPENDABLE FIRE PROTECTION, INC.
12345 SPRINGWOOD DRIVE
SPRINGWOOD, MI 48381
PHONE: 483-4567890

CONTRACTOR: Jon Bryant	REVISION
ADDRESS:	DATE
DATE	BY
5/28/20	CTS
Preconstruction Due Date	
IMPORTANT: TO PREVENT FREEZING OF WATER, SPRINKLER PIPES SHALL BE INSULATED AND HEATED. SPRINKLER PIPES ARE INSTALLED, UNLESS AN ANTI-FREEZE SYSTEM.	

Symbol	Description
Hydraulic Reference Points	
Blav. Below Top of Steel	
Blav. Above Finished Floor	
Blav. of Top/Bottom of Steel	
+ DENOTES HANGER LOCATION	
Denotes Hanger Location	
Rise up or down	




Jon Bryant - Formerly Macy's 3850 Rivertown Parkway, Grandville, MI 49418 Existing Fire Protection Plan	Dependable Fire Protection, Inc. 12345 White Creek Avenue NE, Cedar Springs, MI 49319 PHONE: 483-4567890
---	---

NORTH	
DESIGNER	CTS
SCALE	Noted
CHECK BY	-
FILE NUMBER	TBD
APPROVAL	-
DATE	5/28/2026
DRAWING NO.	FP1 of 3

This drawing is an instrument of service and shall remain the property of Dependable Fire Protection, Inc. whether or not the project for which it is intended is constructed. This drawing and its contents are the property of Dependable Fire Protection, Inc. and shall not be reproduced, copied, or transmitted in any form or by any means, electronic or mechanical, including photocopying, recording, or by any information storage and retrieval system, without the written permission of Dependable Fire Protection, Inc. 12/15/2015
Submission or distribution of this drawing to meet official regulatory requirements or for other purposes in connection with the project is not to be construed as publication in derogation of any of the rights of Dependable Fire Protection, Inc.
Verify existing conditions. Any discrepancies, non-compliance or unclear items shall be reported to Dependable Fire Protection, Inc. in writing, and shall be resolved before the commencement of work.
Any abridgment or violation of the rights of Dependable Fire Protection, Inc. shall be prosecuted to the fullest extent of the law.
Do Not Scale Drawings

HANGER LOCATIONS/MAX. HANGER SPACING PER NFPA								
NOMINAL PIPE SIZE (IN.)	1"	1 1/4"	1 1/2"	2"	2 1/2"	4"	6"	8"
STEEL	12-0	12-0	15-0	15-0	15-0	15-0	15-0	15-0

HANGERS NOT SHOWN, SPACING TO BE PER NFPA 13

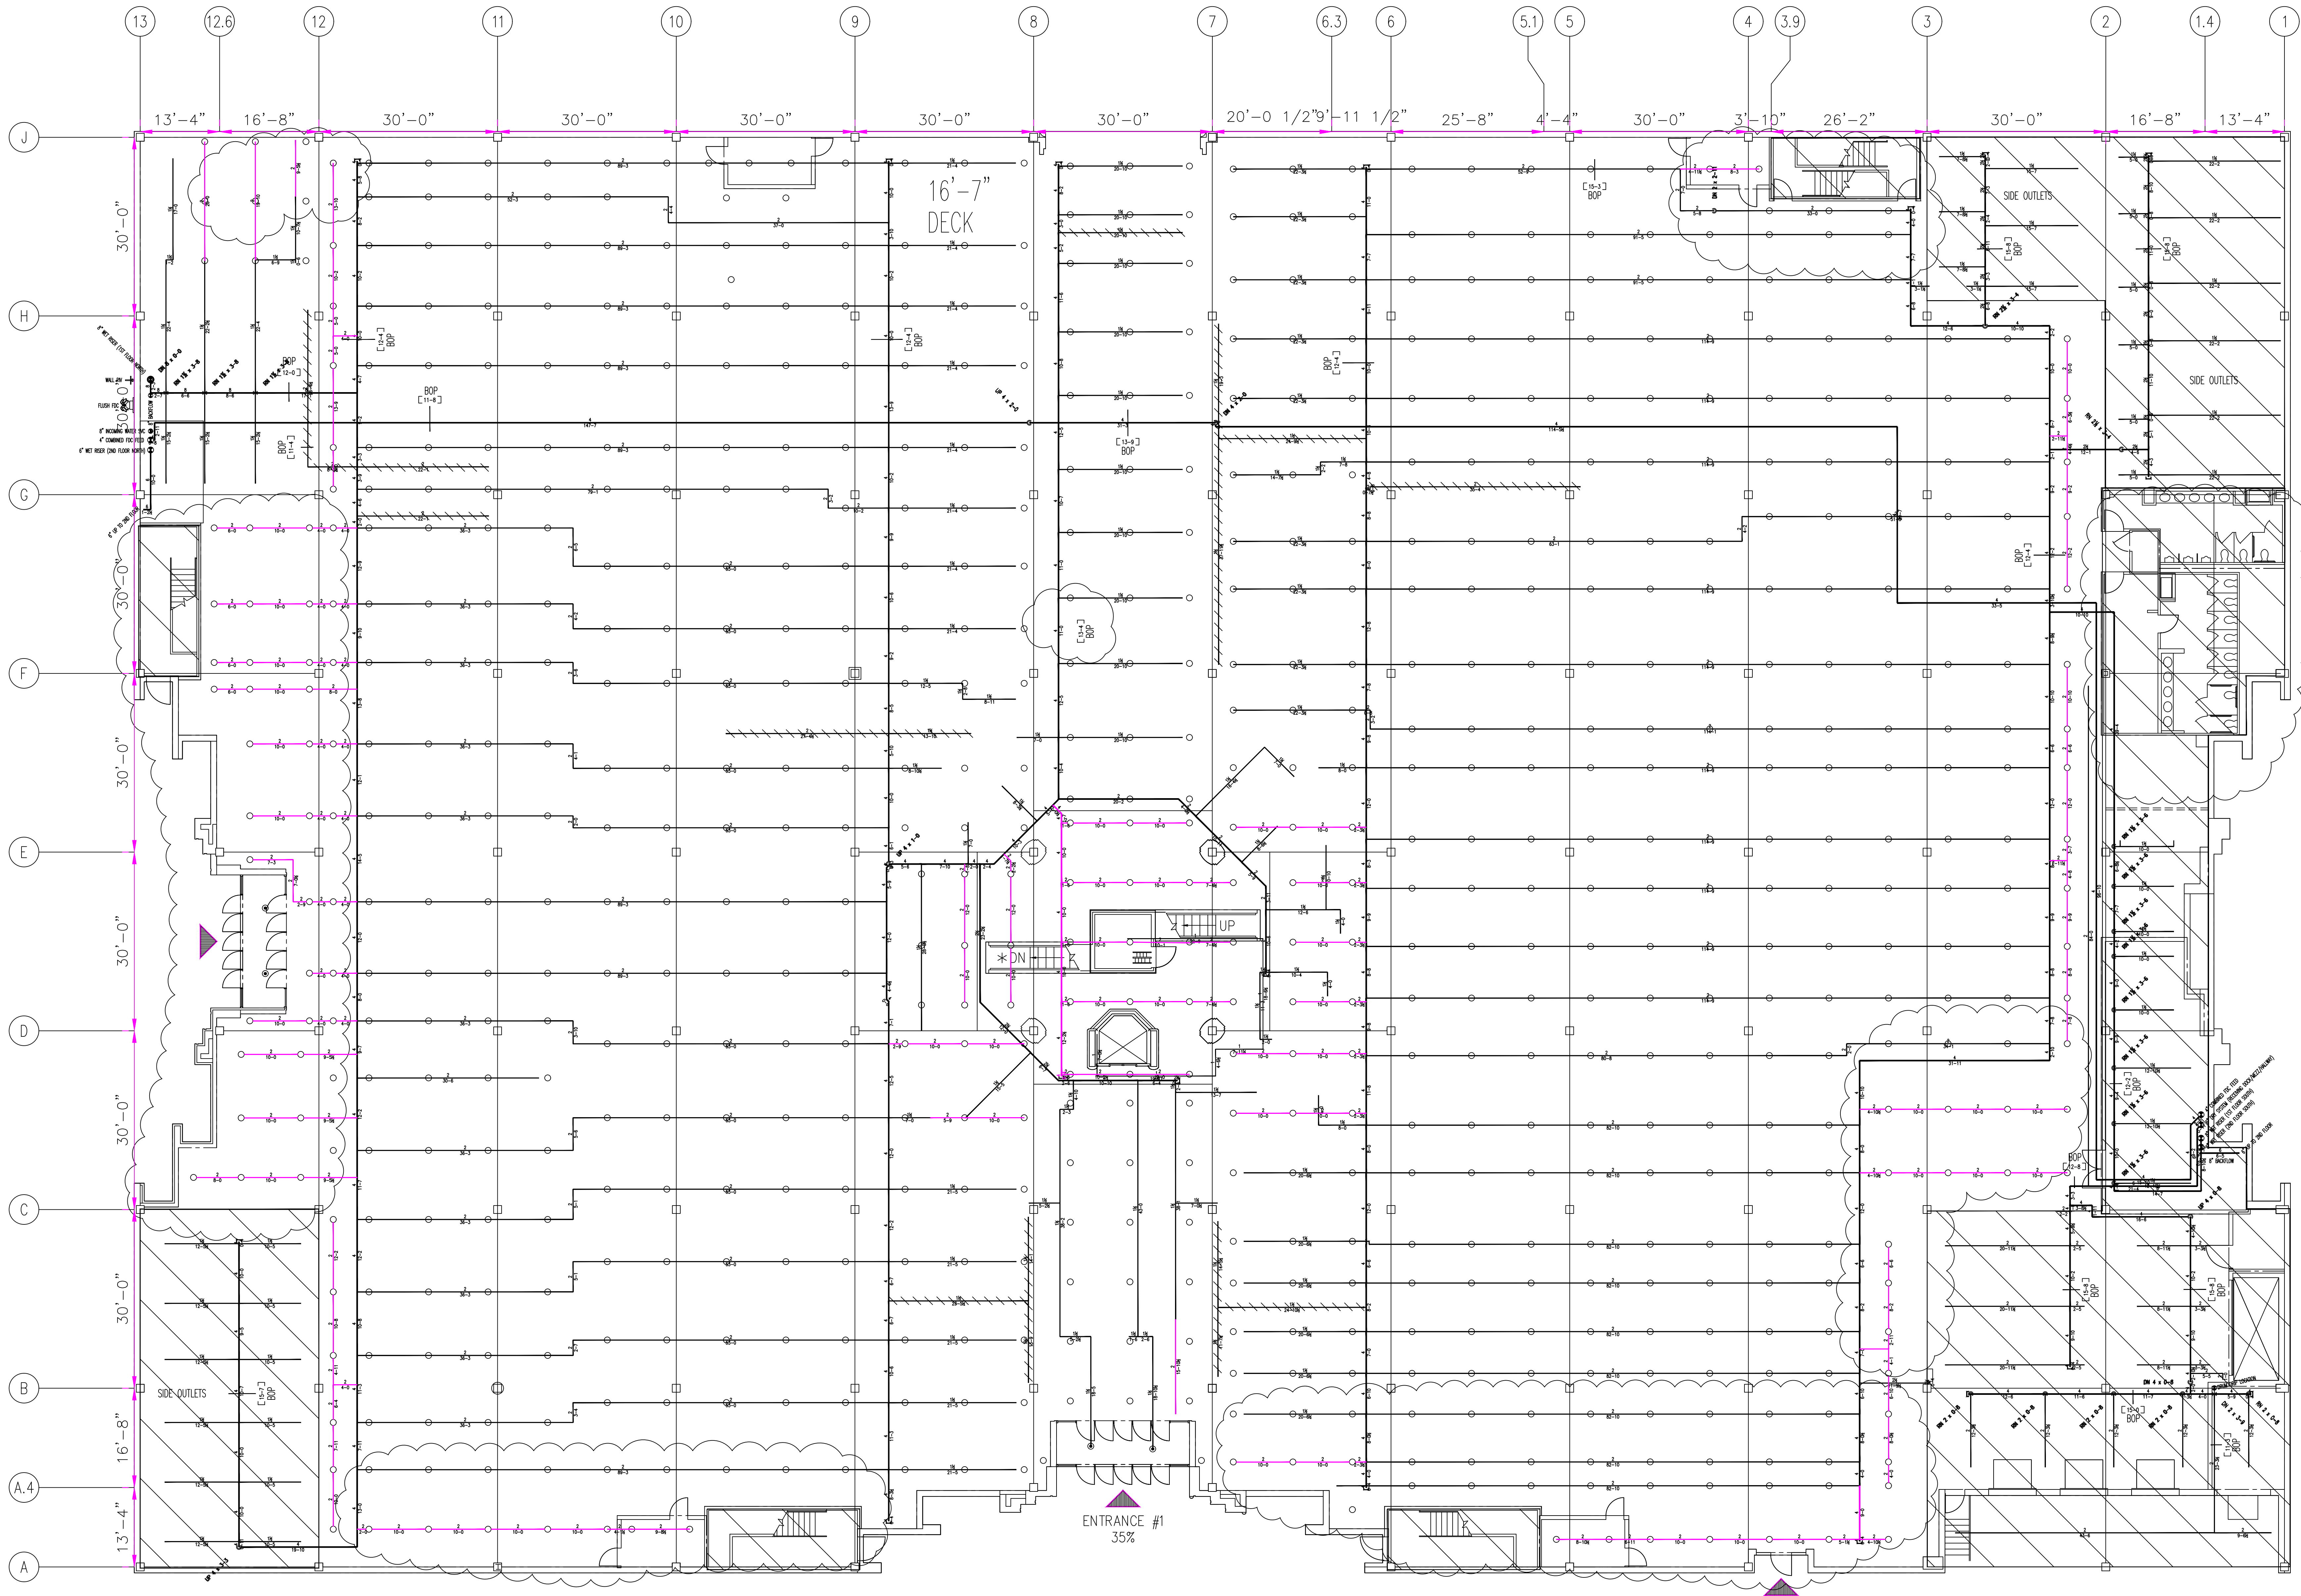

1st Floor Existing Sprinkler Piping Layout

3/32" = 1'-0"

REVISION CLOUDS DENOTE THE AREAS THAT REQUIRE ADDITIONAL SURVEYING ONCE DEMOLITION IS COMPLETE

Sheet Index:
FP1- Notes/Riser/Details
FP2- 1st Floor
FP3- 2nd Floor

WARNING:
THIS DRAWING IS THE PROPERTY OF DEPENDABLE FIRE PROTECTION, INC. AND IS NOT TO BE REPRODUCED OR TRANSMITTED IN ANY FORM OR BY ANY MEANS, ELECTRONIC OR MECHANICAL, INCLUDING PHOTOCOPYING, RECORDING, OR BY ANY INFORMATION STORAGE AND RETRIEVAL SYSTEM, WITHOUT THE WRITTEN PERMISSION OF DEPENDABLE FIRE PROTECTION, INC. ANY VIOLATION OF THIS WARNING IS SUBJECT TO PROSECUTION AND PENALTIES AS PROVIDED BY LAW.

CONTRACTOR: Jon Bryant	
ADDRESS:	
REVISION	
DATE	BY
5/28/2026	CTS
Preconstruction Due Diligence	
IMPORTANT: TO PREVENT FREEZING OF WATER, ALL WET PIPE SPRINKLER PIPING SHALL BE INSULATED AND HEATED. SPRINKLER PIPES ARE INSTALLED, UNLESS AN ANTI-FREEZE SYSTEM.	



Jon Bryant - Formerly Macy's
380 Korum Parkway, Granville, OH 44135
Existing Fire Protection Plan
Dependable
Fire Protection, Inc.
13300 White Creek Avenue NE, Cedar Springs, MI 48319
PHONE: 480.626.8800

NORTH	
DESIGNER	CTS
SCALE	Noted
CHECK BY	-
FILE NUMBER	TBD
APPROVAL	-
DATE	5/28/2026
DRAWING NO. FP2 of 3	

